

NOTE:  
ELECTRICAL PANEL, HOSE BIBBS, A/C UNITS, HOT WATER TANK & FURNACE TO BE LOCATED BY BUILDER.

NOTE:  
BUILDER IS TO REVIEW ALL DRAWINGS BEFORE CONSTRUCTION FOR ANY DISCREPANCIES. IF ANY CONCERN ARISE. PLEASE NOTIFY TLC DESIGNS BEFORE ANY CONSTRUCTION. IF YOU CONTINUE CONSTRUCTION WITHOUT REVIEWING THE PLANS. TLC DESIGNS RESUMES NO RESPONSIBILITIES.

NOTE:  
ALL STRUCTURAL MEMBERS ARE TO BE SIZED & LOCATED BY ENGINEER OR MANUFACTURER. TLC DESIGNS IS NOT RESPONSIBLE TO SIZE OR LOCATE ANY STEEL MEMBERS.


PROJECT # 2021-67	AREAS
1st FLOOR PLAN (INSIDE)	873 SQ. FT.
1st FLOOR PLAN (OUTSIDE)	946 SQ. FT.

SQ. FT. FROM OUTSIDE STUD WALLS

**T L C**  
**DESIGNS**  
DRAFTING SERVICES

117 KENTON WAY. \* GEORGETOWN, KY 40324  
PHONE \* (859)338-6367

**PROPOSED**  
**FLOOR PLAN**  
SCALE: 1/4" = 1'-0"

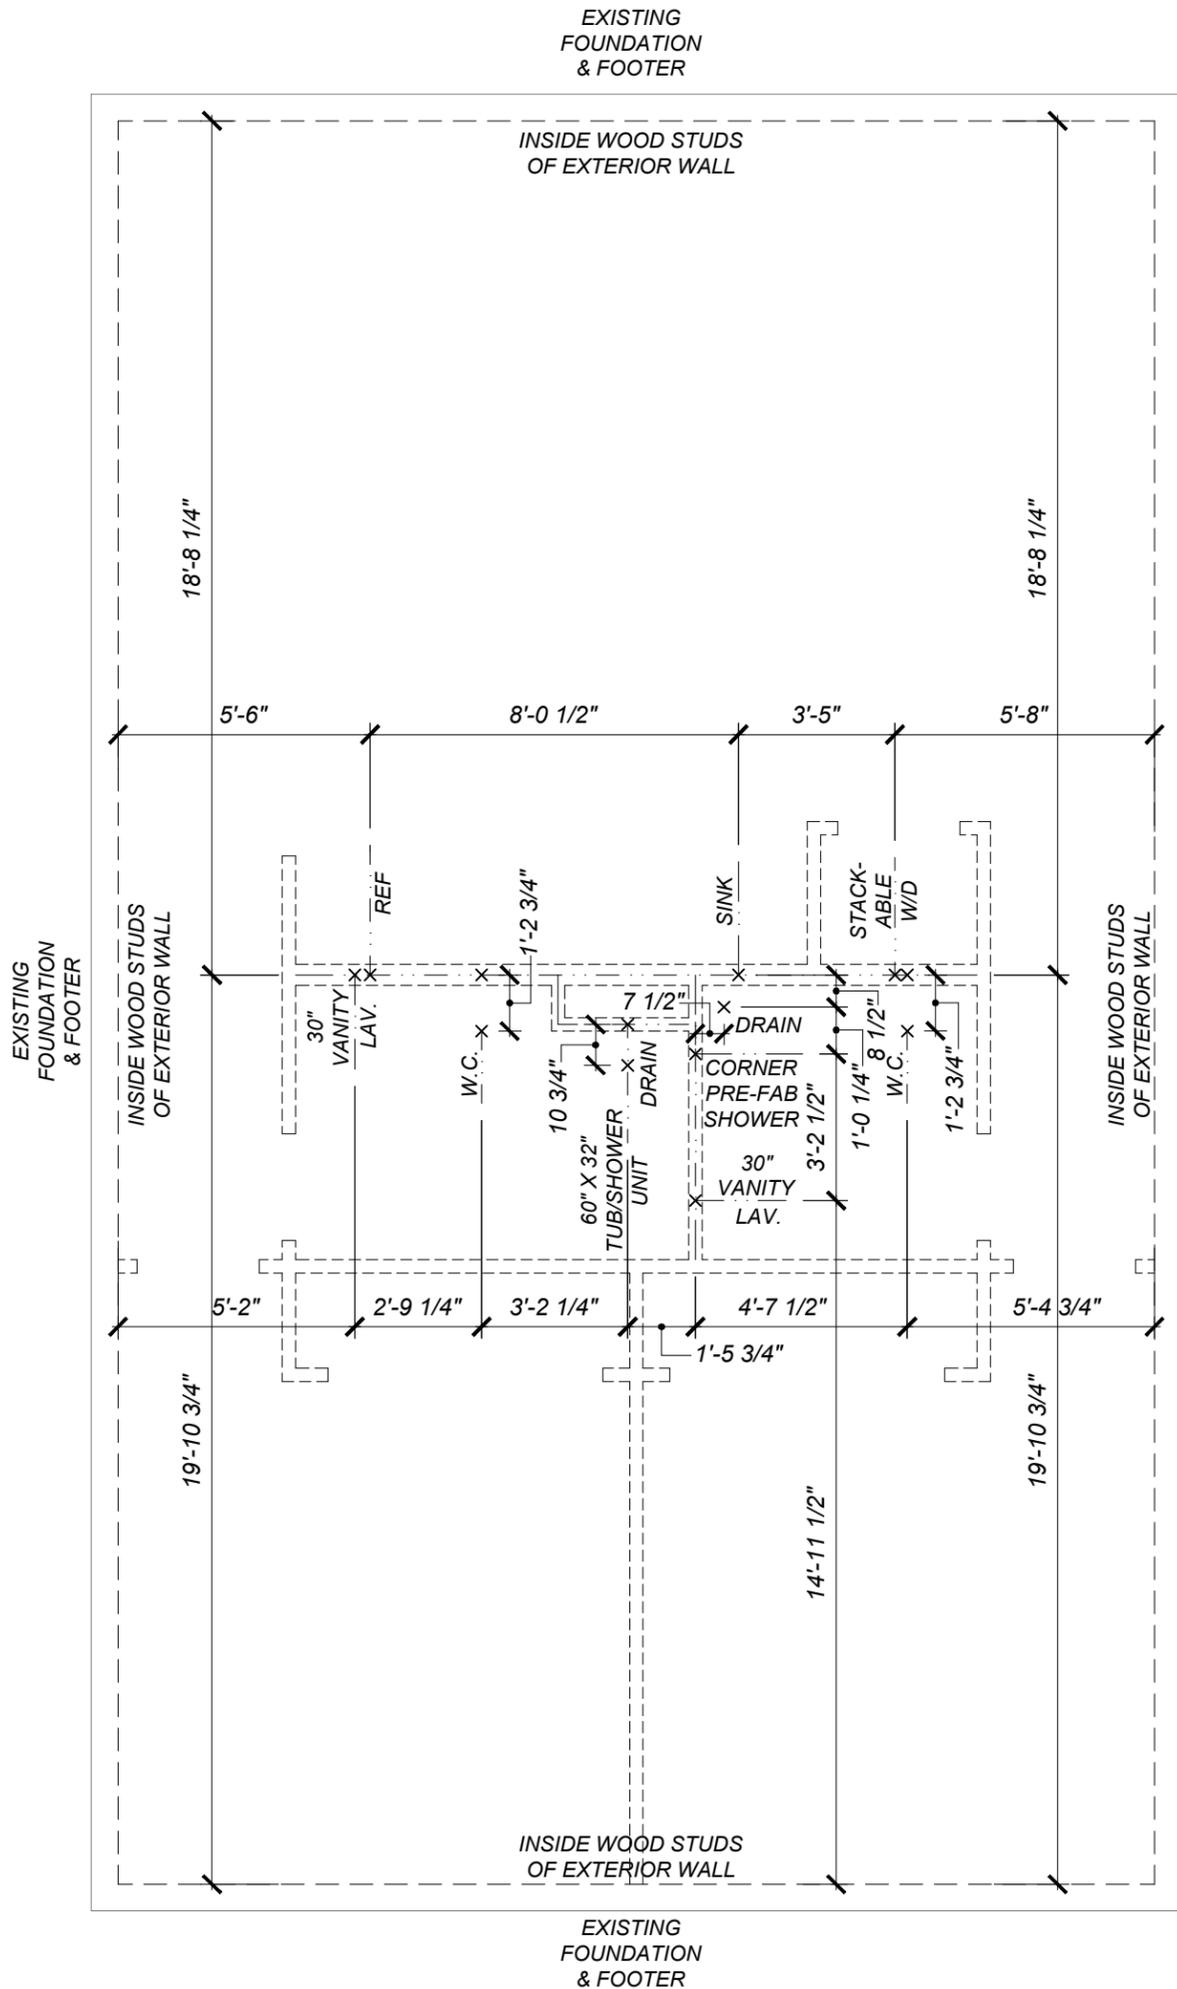

NOTE:  
ELECTRICAL PANEL, HOSE BIBBS, A/C UNITS, HOT WATER TANK & FURNACE TO BE LOCATED BY BUILDER.

NOTE:  
BUILDER IS TO REVIEW ALL DRAWINGS BEFORE CONSTRUCTION FOR ANY DISCREPANCIES. IF ANY CONCERN ARISE. PLEASE NOTIFY TLC DESIGNS BEFORE ANY CONSTRUCTION. IF YOU CONTINUE CONSTRUCTION WITHOUT REVIEWING THE PLANS. TLC DESIGNS RESUMES NO RESPONSIBILITIES.

NOTE:  
ALL STRUCTURAL MEMBERS ARE TO BE SIZED & LOCATED BY ENGINEER OR MANUFACTURER. TLC DESIGNS IS NOT RESPONSIBLE TO SIZE OR LOCATE ANY STEEL MEMBERS.

**T L C**  
**DESIGNS**  
**DRAFTING SERVICES**

117 KENTON WAY. \* GEORGETOWN, KY 40324  
PHONE \* (859)338-6367

**SLAB FOUNDATION**  
**PLAN**

SCALE: 1/4" = 1'-0"